



Leon County

Board of County Commissioners

301 South Monroe Street, Tallahassee, Florida 32301
(850) 606-5302 www.leoncountyfl.gov

Purchasing Division
1800-3 Blair Stone Road
(corner of Miccosukee and Blair Stone Roads)
Tallahassee, Florida 32308
(850) 606-1600

Commissioners

BILL PROCTOR
District 1

JANE G. SAULS
District 2

JOHN DAILEY
District 3

BRYAN DESLOGE
District 4

KRISTIN DOZIER
District 5

NICK MADDOX
At-Large

AKIN AKINYEMI
At-Large

VINCENT S. LONG
County Administrator

HERBERT W.A. THIELE
County Attorney

October 4, 2011

RE: Bid Title: Leon County Sustainable Demonstration Center - Geothermal Loop
HVAC System; Bid No. BC-10-11-11-07
Opening Date: Tuesday, October 11, 2011 at 3:30

ADDENDUM #1

Dear Vendor:

This letter serves as Addendum #1 for the above referenced project.



Please see the attached Addendum 1 from H2 Engineering, Inc.

Acknowledgment of this addendum is required as part of your bid submittal. Failure to acknowledge this addendum may result in rejection of your bid.

Should you have any questions, feel free to call me at (850) 606-1600.

Sincerely,

Keith M. Roberts
Purchasing Director

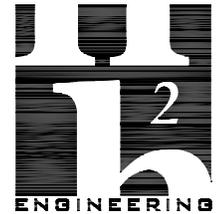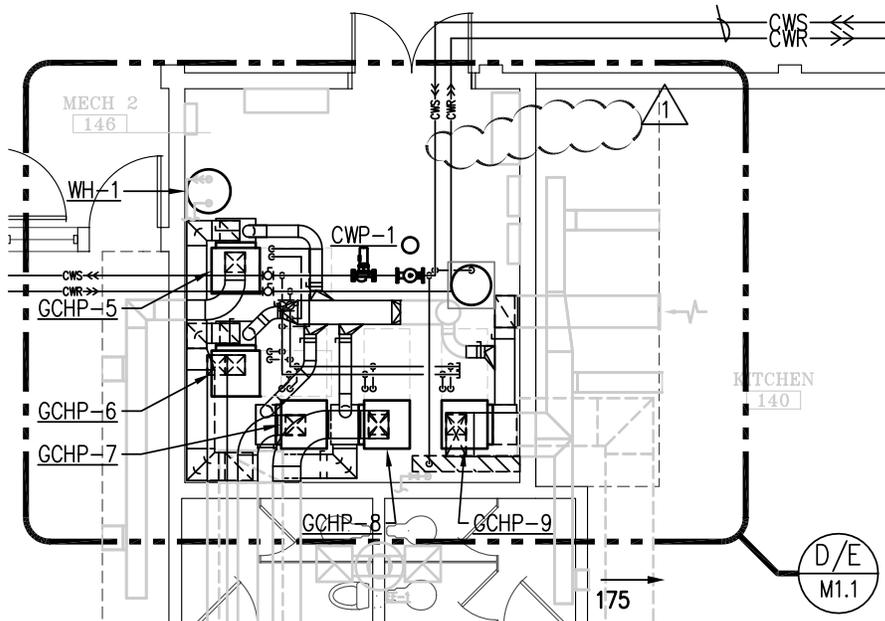

114 EAST 5th AVENUE TALLAHASSEE, FL
32303 PHONE 850.224.7922
www.H2Engineering.com

H2E PROJECT No. 1105


THIS DOCUMENT IS THE PROPERTY OF H2ENGINEERING AND IS PREPARED AS AN INSTRUMENT OF SERVICE. ITS USE, REUSE, OR REPRODUCTION, EXCEPT BY WRITTEN AGREEMENT WITH H2ENGINEERING, IS PROHIBITED.

Florida Certificate of Authorization #2485
Ryan L. Chewning, P.E. #63103

1
M1.1

FLOOR PLAN - HVAC

1/8"=1'-0"

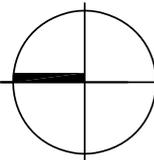

NORTH



10522 Drawn By: CJB
Project Code Checked By: DMH/RLC

12 Sept. 2011

Date
100% Construction Documents
Bid Package # 2

Revisions
▲ 10/4/11 Addendum #1




Leon County - Sustainable Demonstration Center
Tallahassee Florida

SD M1.1 A


Ref. Sheet: M1.1

225 SOUTH ADAMS ST., TALLAHASSEE, FLORIDA 32301
PHONE 850 224-6301 FAX 850 561-6978

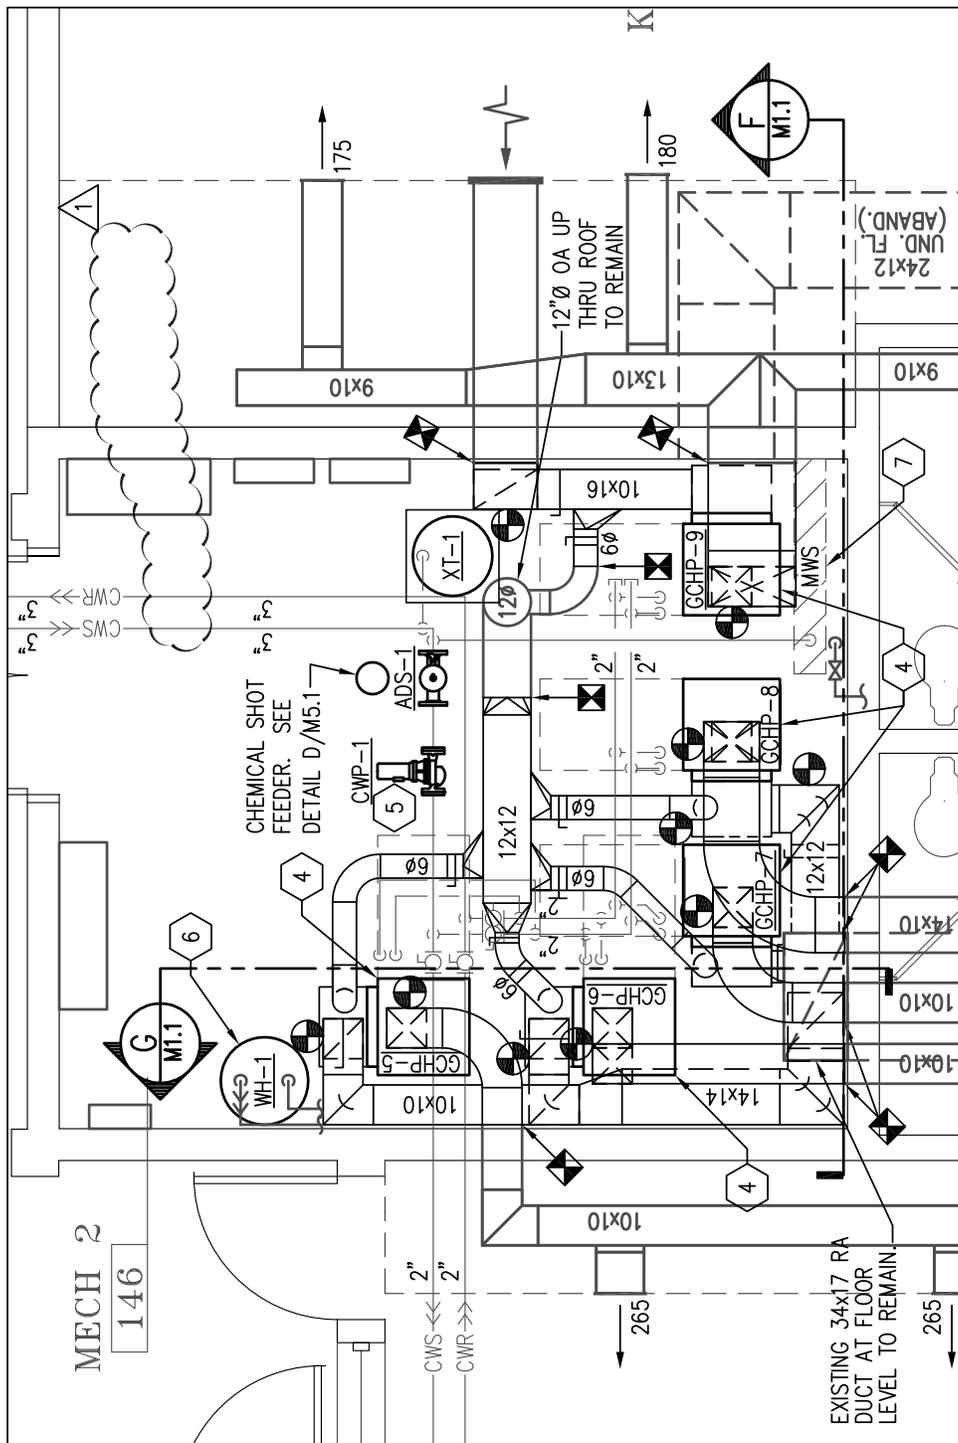

D ENLARGED PLAN - DUCTWORK

M1.1
1/4"=1'-0"

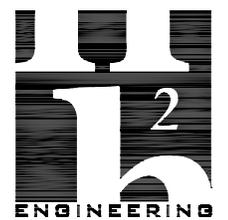

114 EAST 5th AVENUE TALLAHASSEE, FL
32303 PHONE 850.224.7922
www.H2Engineering.com
H2E PROJECT No. 1105
THIS DOCUMENT IS THE PROPERTY OF H2ENGINEERING AND IS PREPARED AS AN INSTRUMENT OF SERVICE. ITS USE, REUSE, OR REPRODUCTION, EXCEPT BY WRITTEN AGREEMENT WITH H2ENGINEERING, IS PROHIBITED.
Florida Certificate of Authorization #2485
Ryan L. Chewning, P.E. #63103



10522 Drawn By: CJB
Project Code Checked By: DMH/RLC


12 Sept. 2011
Date
100% Construction Documents
Bid Package # 2

Revisions

▲	10/4/11	Addendum #1
▲		
▲		
▲		

Leon County - Sustainable Demonstration Center
Tallahassee Florida


SD M1.1 B
Ref. Sheet: M1.1
225 SOUTH ADAMS ST., TALLAHASSEE, FLORIDA 32301
PHONE 850 224-6301 FAX 850 561-6978

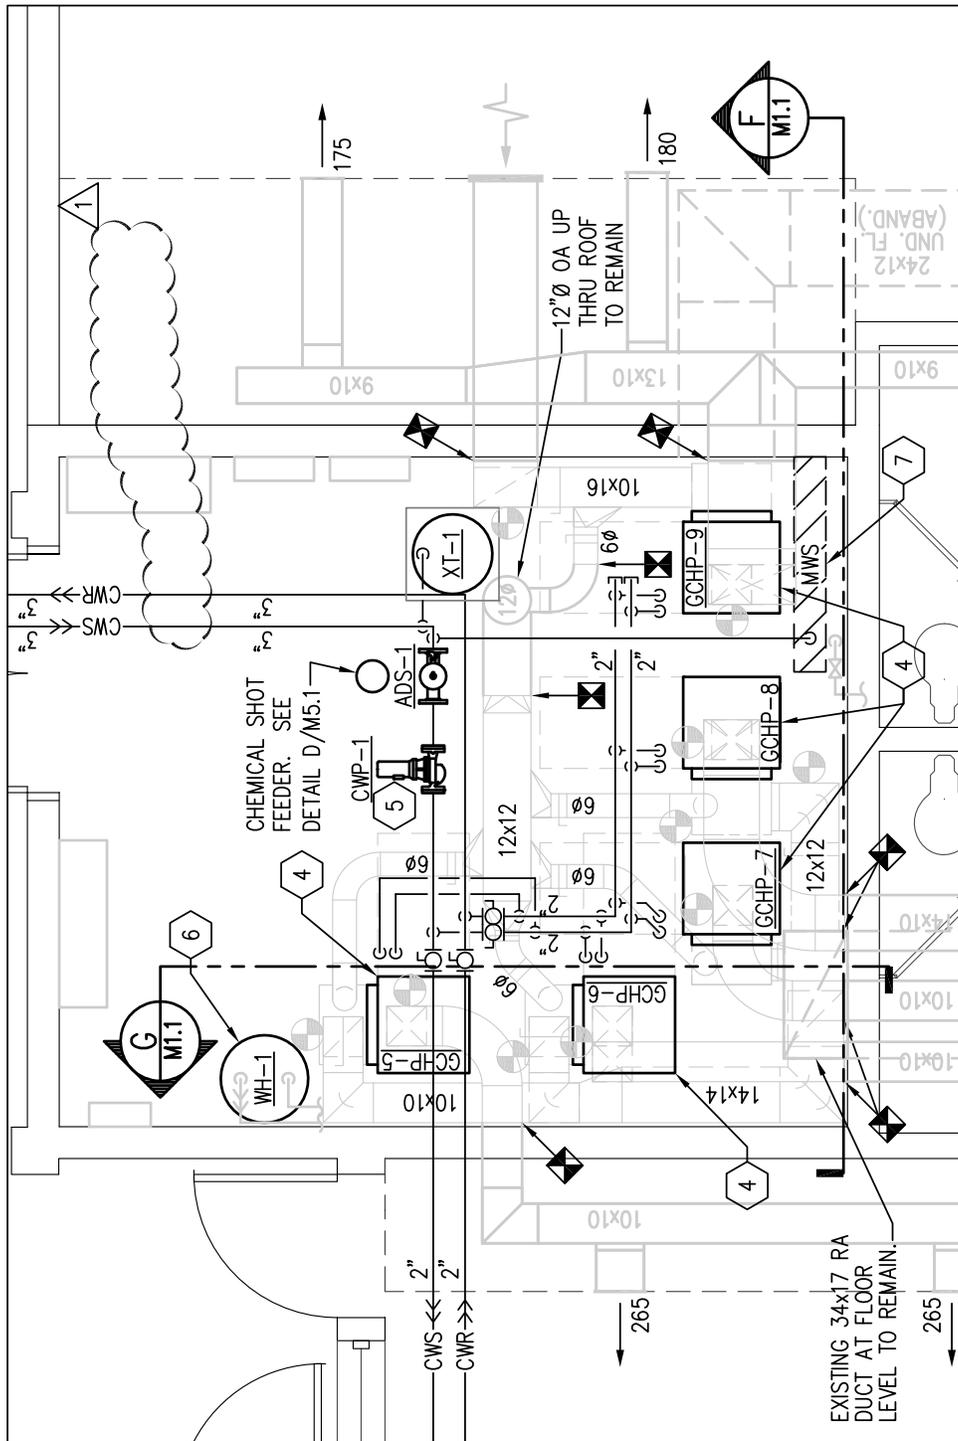

ENLARGED PLAN - PIPING

E
M1.1

1/4"=1'-0"

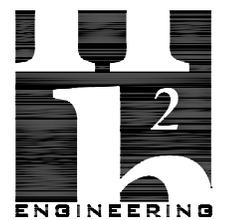

114 EAST 5th AVENUE TALLAHASSEE, FL
 32303 PHONE 850.224.7922
 www.H2Engineering.com
 H2E PROJECT No. 1105
 THIS DOCUMENT IS THE PROPERTY OF H2ENGINEERING AND IS PREPARED AS AN INSTRUMENT OF SERVICE. ITS USE, REUSE OR REPRODUCTION, EXCEPT BY WRITTEN AGREEMENT WITH H2ENGINEERING, IS PROHIBITED.
 Florida Certificate of Authorization #2485
 Ryan L. Chewning, P.E. #63103



10522 Drawn By: CJB
 Project Code Checked By: DMH/RLC

12 Sept. 2011
 Date
 100% Construction Documents
 Bid Package # 2

Revisions

▲	10/4/11	Addendum #1
▲		
▲		
▲		

Leon County - Sustainable Demonstration Center
 Tallahassee Florida

SD M1.1 C
 Ref. Sheet: M1.1
 225 SOUTH ADAMS ST., TALLAHASSEE, FLORIDA 32301
 PHONE 850 224-6301 FAX 850 561-6978

